



OPTIMIST PARK - DOG PARK/BASKETBALL COURT PROJECT

COVER SHEET

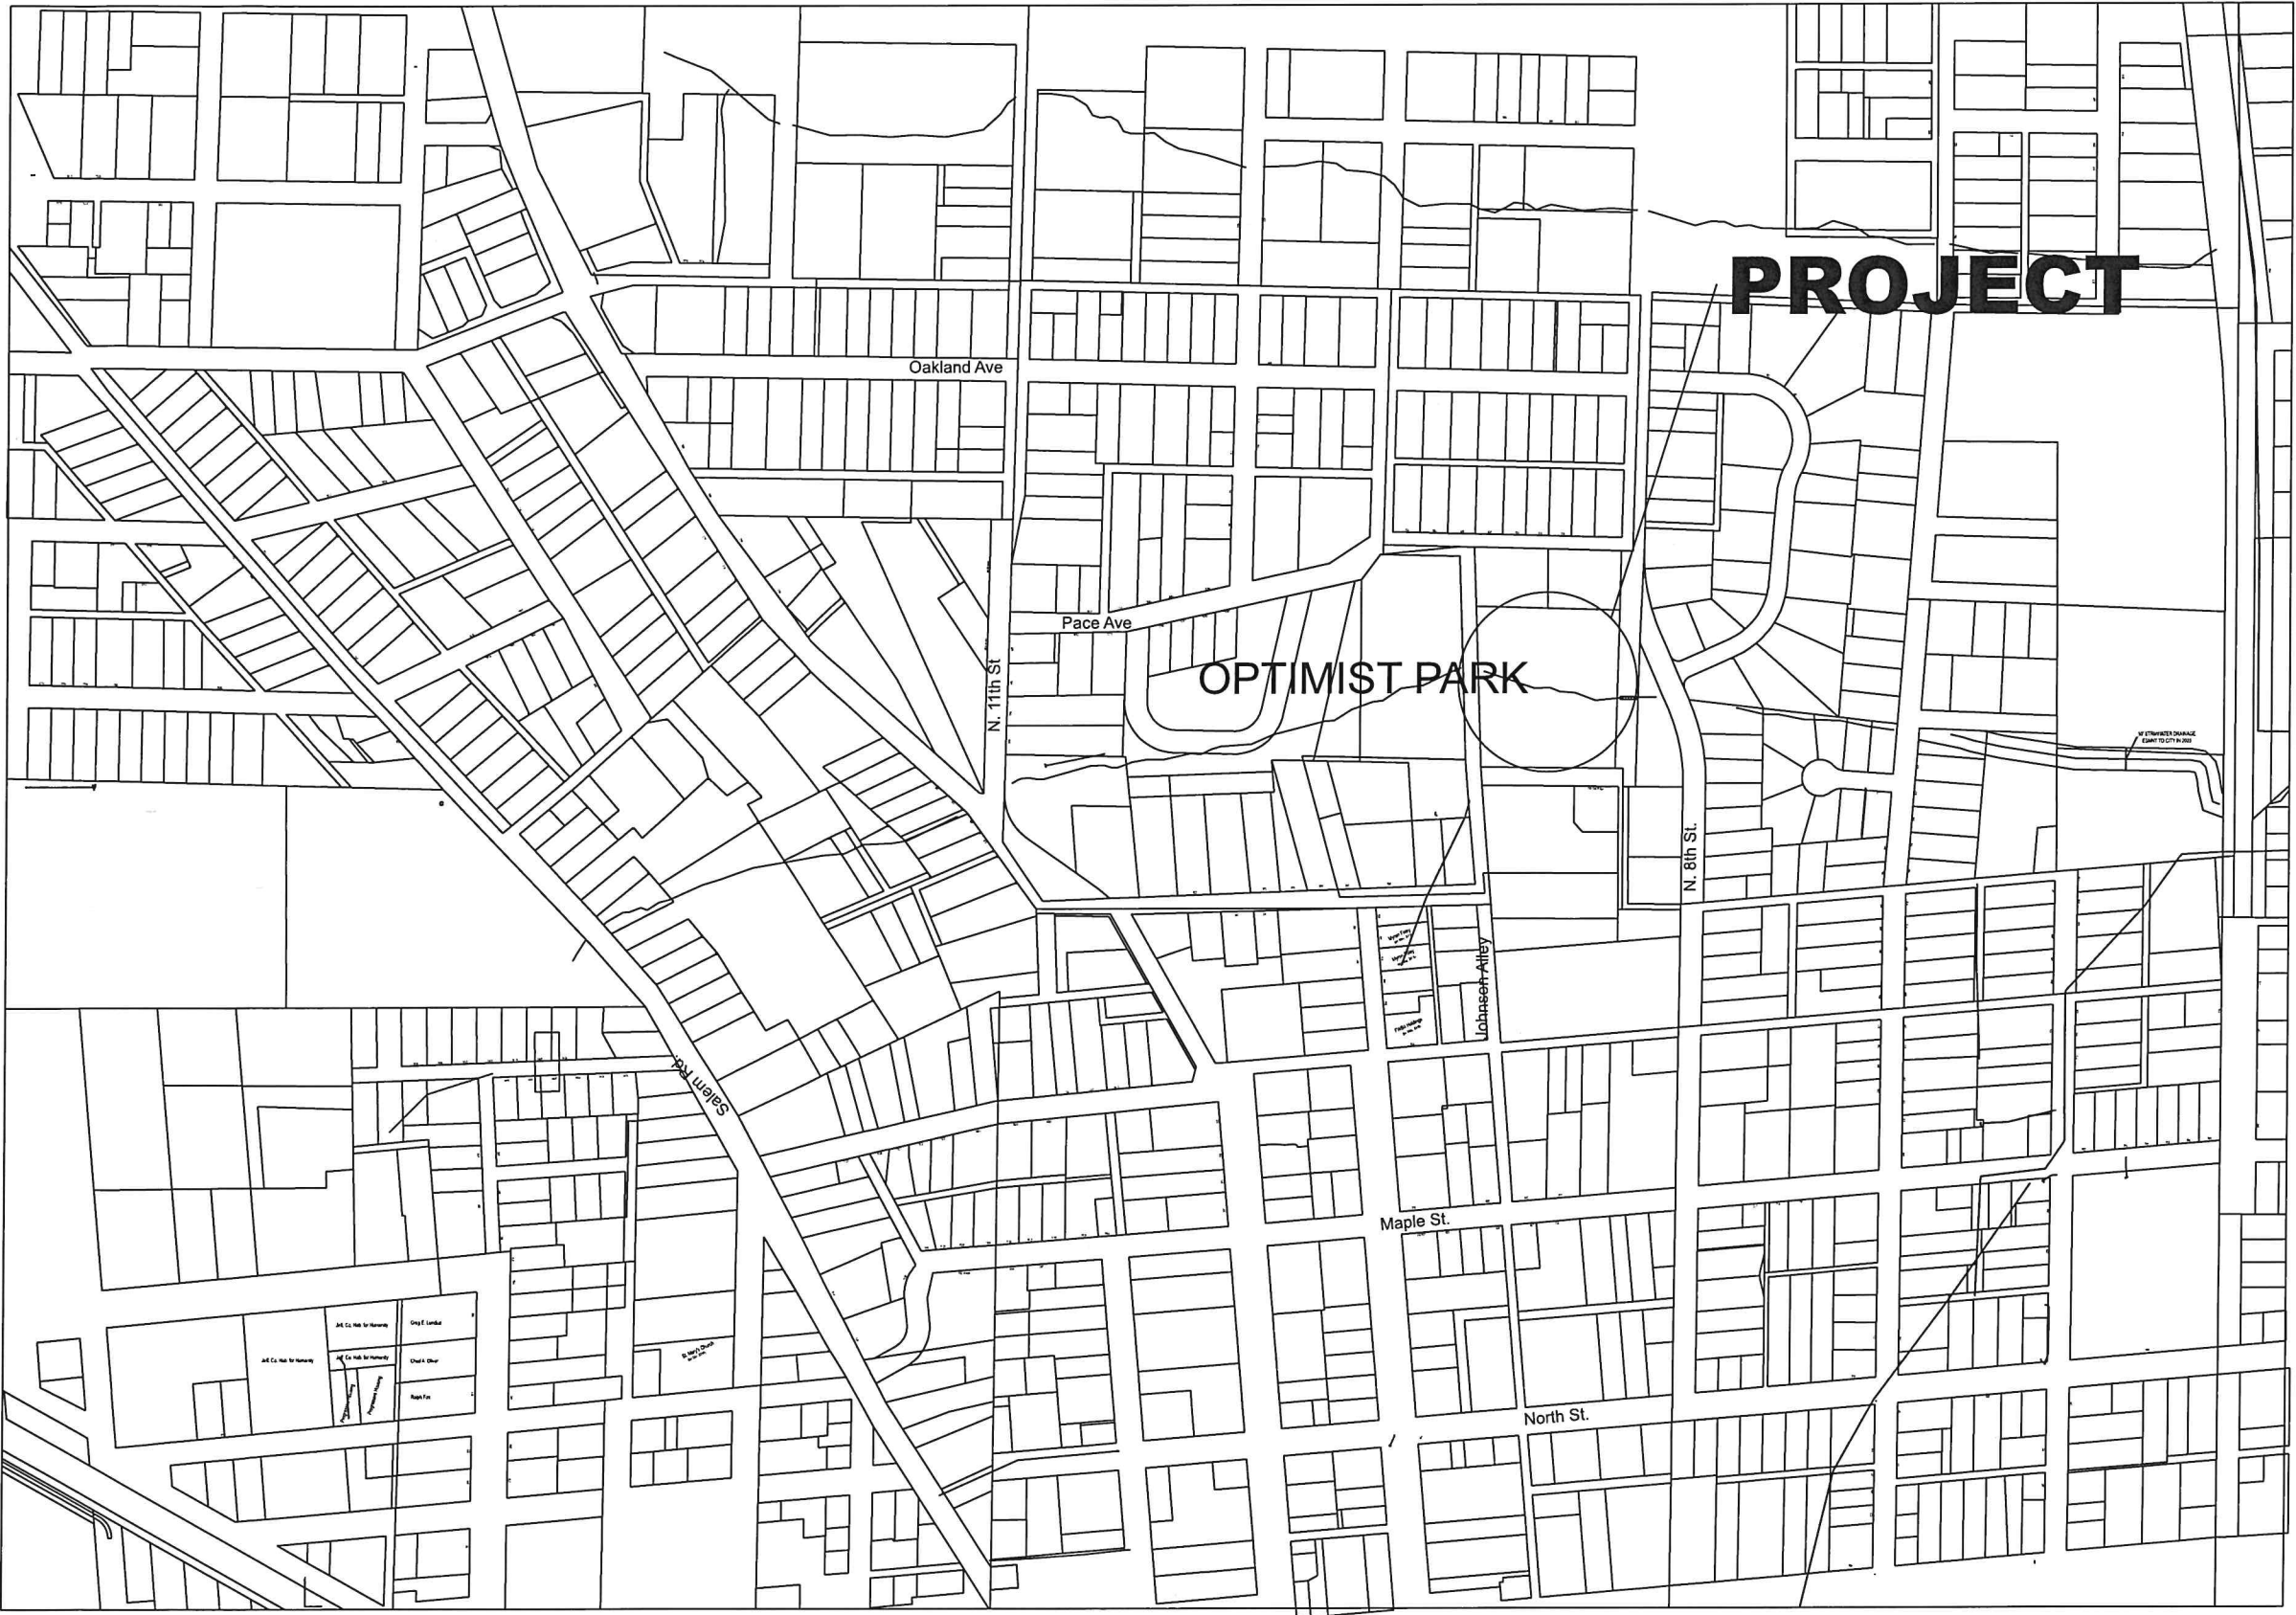

SCHEDULE OF DRAWINGS

SHEET 1	Cover Sheet
SHEET 2	Overall Site Plan
SHEET 3	Dog Park Plan
SHEET 4	Basketball Court Plan

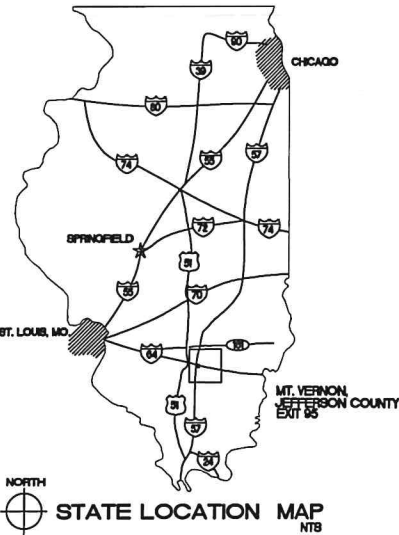

LOCAL UTILITIES
GAS AND ELECTRIC
ILLINOIS POWER COMPANY
CONTACT: MIKE TATLOCK, ENGINEER
PH: 618-244-8271
ELECTRIC
TRI-COUNTY ELECTRIC, INC.
CONTACT: BRAD GRUBB
PH: 618-244-5151
TELEPHONE
AMERITECH
CONTACT: DISTRICT ENGINEER
PH: 618-533-3411
CABLE TV
CHARTER COMMUNICATIONS
PH: 618-244-9382
CITY PUBLIC WORKS DEPARTMENT
CONTACT: MATT FAUSS, P.E.
PH: 618-242-6853
and
CONTACT: STEPHEN TALLEY
PH: 618-242-6850

CITY OF MOUNT VERNON

OPTIMIST PARK - DOG PARK/BASKETBALL COURT PROJECT


Overall Site Plan




Scale 1" = 50'



CITY OF MOUNT VERNON

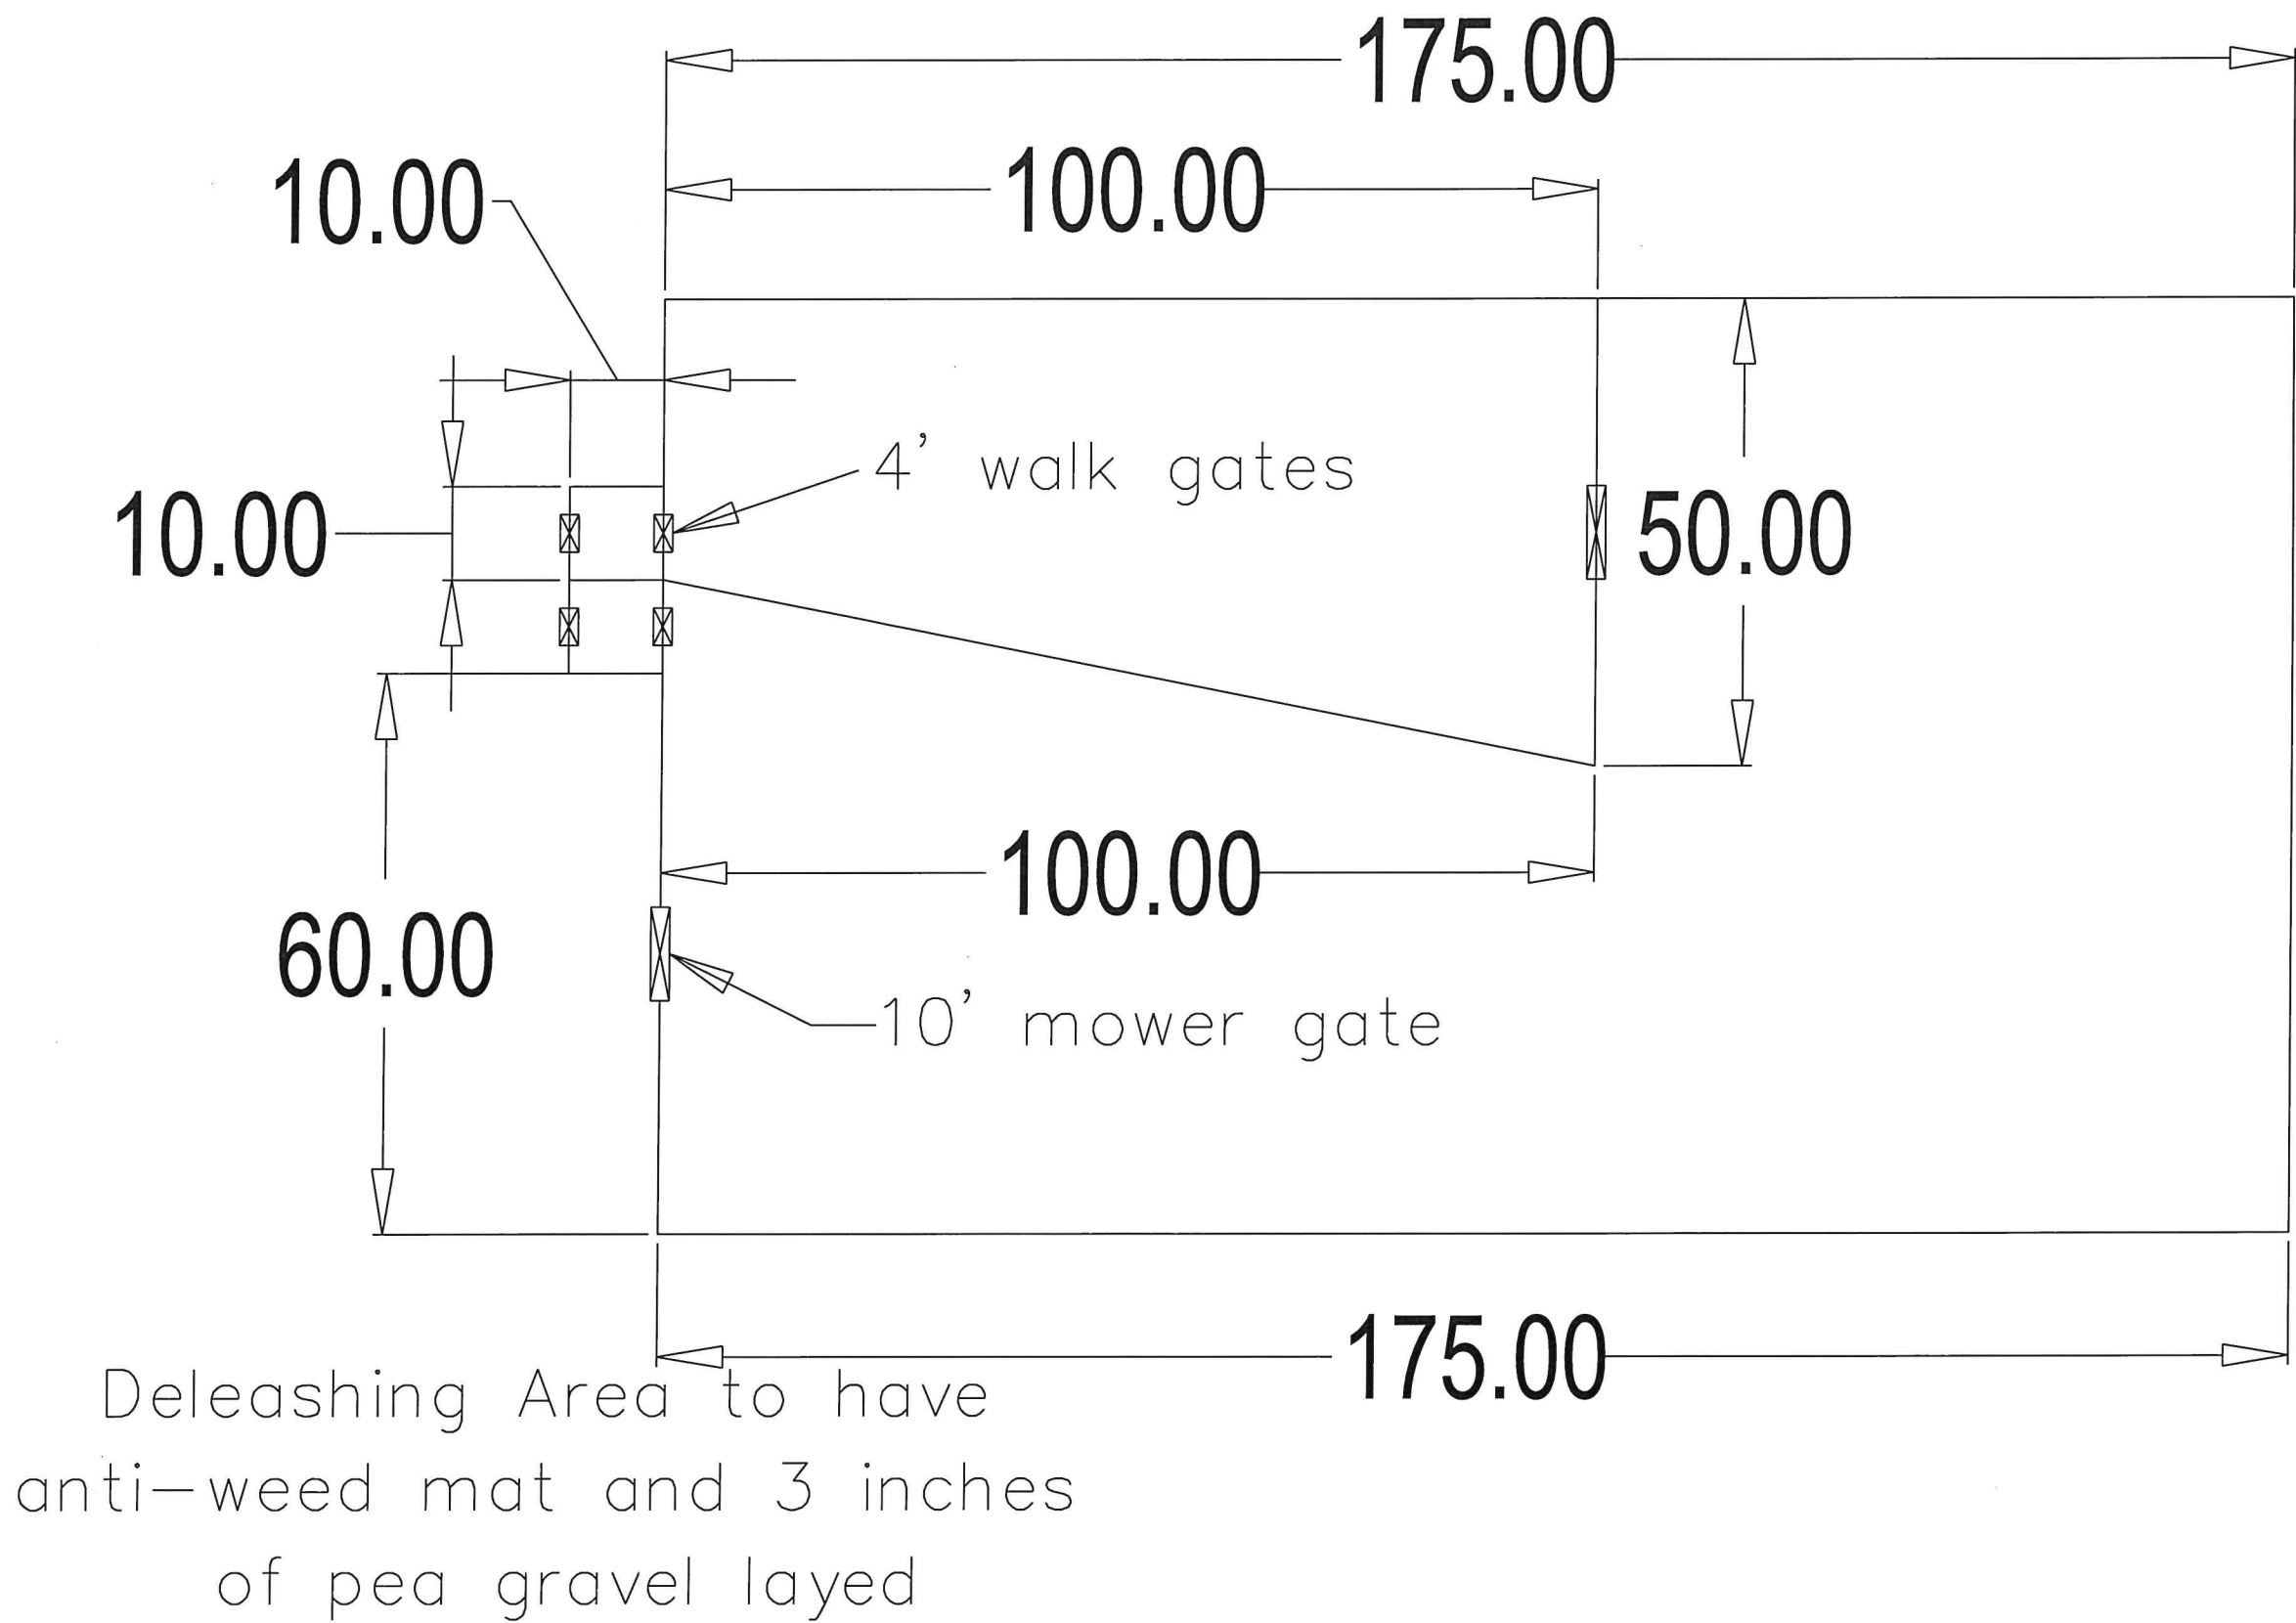

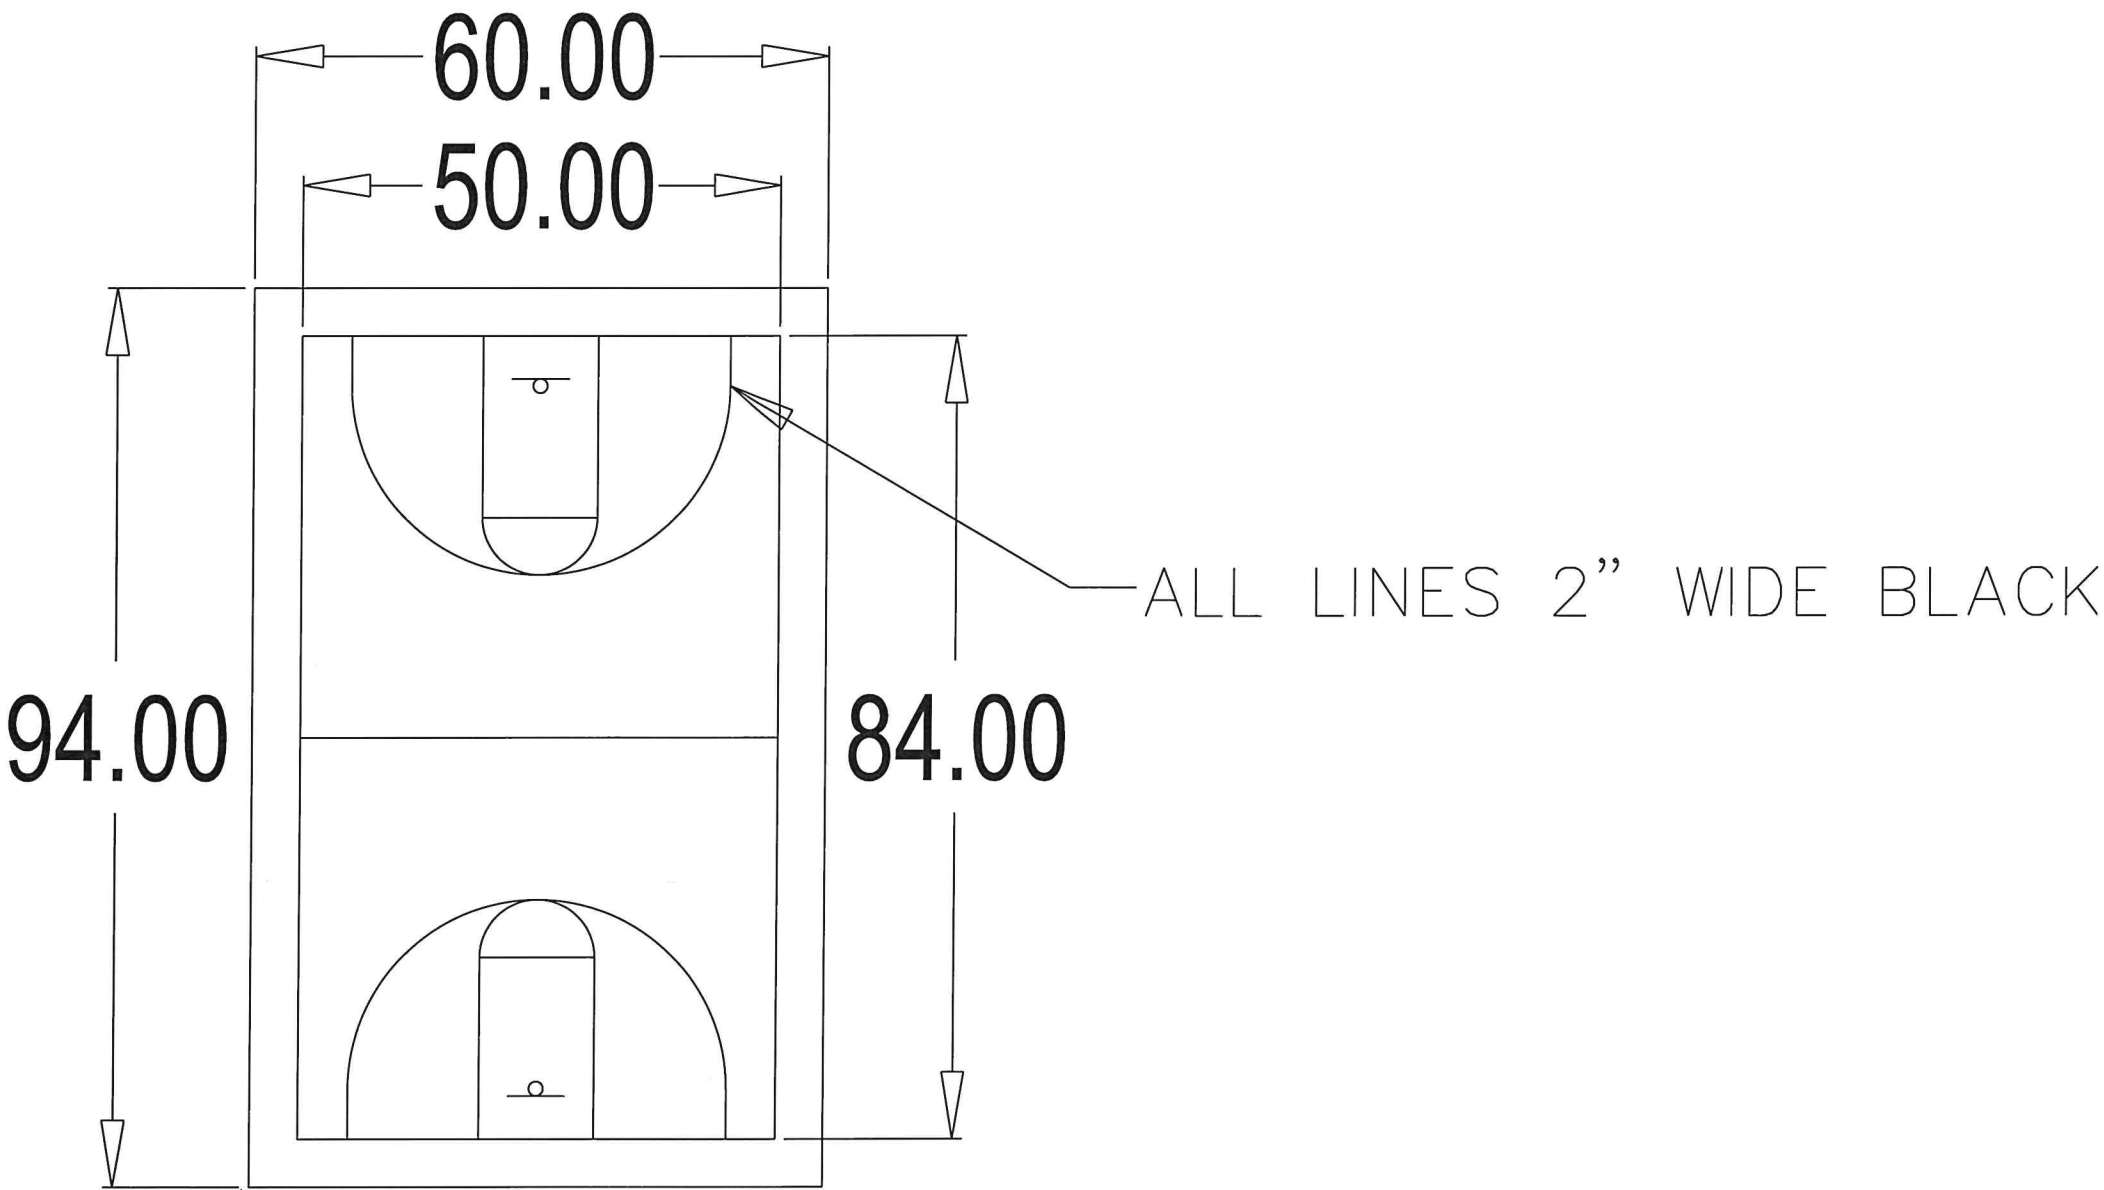

Basketball Court Striping
Should conform to IHSA
Guidelines. Free Throw
Line, 3 Point Line, Lane,
Center Court Lines, and Perimeter Lines

